

JOINT FORCES HEADQUARTERS

AUGUSTA, MAINE

INDEX

DRAWING INDEX

G001	COVER SHEET
C-001	SITE GENERAL NOTES AND ABBREVIATIONS
C-002	SITE VICINITY PLAN
C-003	SITE LOCATION MAP
CS101	SITE EXISTING CONDITIONS PLAN
CD100	SITE OVERALL REMOVALS PLAN
CD101	SITE REMOVALS PLAN
CD102	SITE REMOVALS PLAN
CD103	SITE REMOVALS PLAN
CP100	SITE OVERALL LAYOUT & MATERIALS PLAN
CP101	SITE LAYOUT & MATERIALS PLAN
CP102	SITE LAYOUT & MATERIALS PLAN
CP103	SITE LAYOUT & MATERIALS PLAN
CG100	SITE OVERALL GRADING & EROSION CONTROL PLAN
CG101	SITE GRADING & EROSION CONTROL PLAN
CG102	SITE GRADING & EROSION CONTROL PLAN
CG103	SITE GRADING & EROSION CONTROL PLAN
CU100	SITE OVERALL SEWER, WATER, & GAS PLAN
CU101	SITE SEWER, WATER, & GAS PLAN
CU102	SITE SEWER, WATER, & GAS PLAN
CW100	SITE OVERALL STORM DRAINAGE PLAN
CW101	SITE STORM DRAINAGE PLAN
CW102	SITE STORM DRAINAGE PLAN
CW103	SITE STORM DRAINAGE PLAN
ES100	SITE OVERALL ELECTRICAL PLAN
ES101	SITE ELECTRICAL PLAN
ES102	SITE ELECTRICAL PLAN
ES103	SITE ELECTRICAL PLAN
C501	SITE DETAILS
C502	SITE DETAILS
C503	SITE DETAILS
C504	SITE DETAILS
C505	SITE DETAILS
C506	SITE DETAILS
ES001	SITE DETAILS
LP101	SITE PLANTING PLAN
LP102	SITE PLANTING PLAN
LP103	SITE PLANTING PLAN
SW101	PRE-STORMWATER PLAN
SW102	POST-STORMWATER PLAN
SW103	STORMWATER TREATMENT PLAN



WBRC

ARCHITECTS • ENGINEERS

BANGOR, MAINE
207-947-4511

PORTLAND, MAINE
207-828-4511

SARASOTA, FLORIDA
941-556-0757

www.wbrcae.com



THIS IS TO CERTIFY THAT AFTER REVIEWING THE SITE PLAN SUBMISSION INFORMATION FOR THE PROJECT SHOWN ON THE PLAN AND CONSIDERING EACH OF THE CRITERIA SET FORTH IN THE CITY ORDINANCE, THE UNDERSIGNED HAVE MADE FINDING OF FACT ESTABLISHING THAT THIS PLAN ALONG WITH ITS ADDITIONAL SUBMISSION MATERIAL HAS MET ALL THE CRITERIA SET FORTH AND THEREFORE THE SITE PLAN IS APPROVED.

PLANNING BOARD APPROVED ON: _____

CONDITIONS: _____

PLANNING BOARD SIGNED ON: _____

APPROVAL DRAWINGS
5.7.13

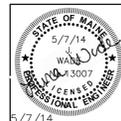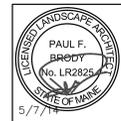

SHEET No.
GI001

COMM. No.
3752.00



PLAN REFERENCE:
 1. THE BOUNDARY INFORMATION SHOWN ON THIS PLAN IS BASED ON A SITE SURVEY PROVIDED BY MORRIS LAND SURVEYORS, PROJECT # AJ152K, DATED 01-18-2012.
 2. WETLANDS, PVP & STREAM CENTERLINE GIS INFORMATION PROVIDED BY CES INC. RECEIVED 03-14-2012.

THIS INFORMATION IS NOT PART OF THE CONTRACT DOCUMENTS AND IS FOR INFORMATIONAL PURPOSES ONLY

REV.	DESCRIPTION	DATE

APPROVAL DRAWINGS
 05.07.14

CURRENT ISSUE STATUS:



WBRC
 ARCHITECTS + ENGINEERS
 WWW.WBRC-AE.COM
 BANGOR, MAINE 05901-4011
 PORTLAND, MAINE 307-828-4111
 SUWANEE, FLORIDA 317-554-0757


O'BrienAtkins
 Architects | Engineers | Planners | Scientists | Environmental & Landscape Design
 O'BrienAtkins Associates, PA 914 941 3020 - Durham
 PO Box 1025 914 941 3025 - Raleigh
 Research Triangle Park 914 941 3000 - Fax
 1000 Capital City 914 941 3070

JOINT FORCE
 HEADQUARTERS -
 PHASE I PN, 230113
 PROJECT: AUGUSTA, MAINE

SITE LOCATION
 MAP

SHEET TITLE:	375200 SP101.DWG
PROJECT NO.:	3752.00
SCALE:	1"=200'
PROJECT MANAGER:	MLW
DRAWN BY:	TAR
CHECKED BY:	ARB/PAM
SHEET NO.:	C-003

Map 05_07_14.dwg
 10:00am
 4/20/14 3:25:23
 C:\BPI-300\BPI-300\Drawings\Design\Drawings\375200 SP101.dwg
 arbs.pam

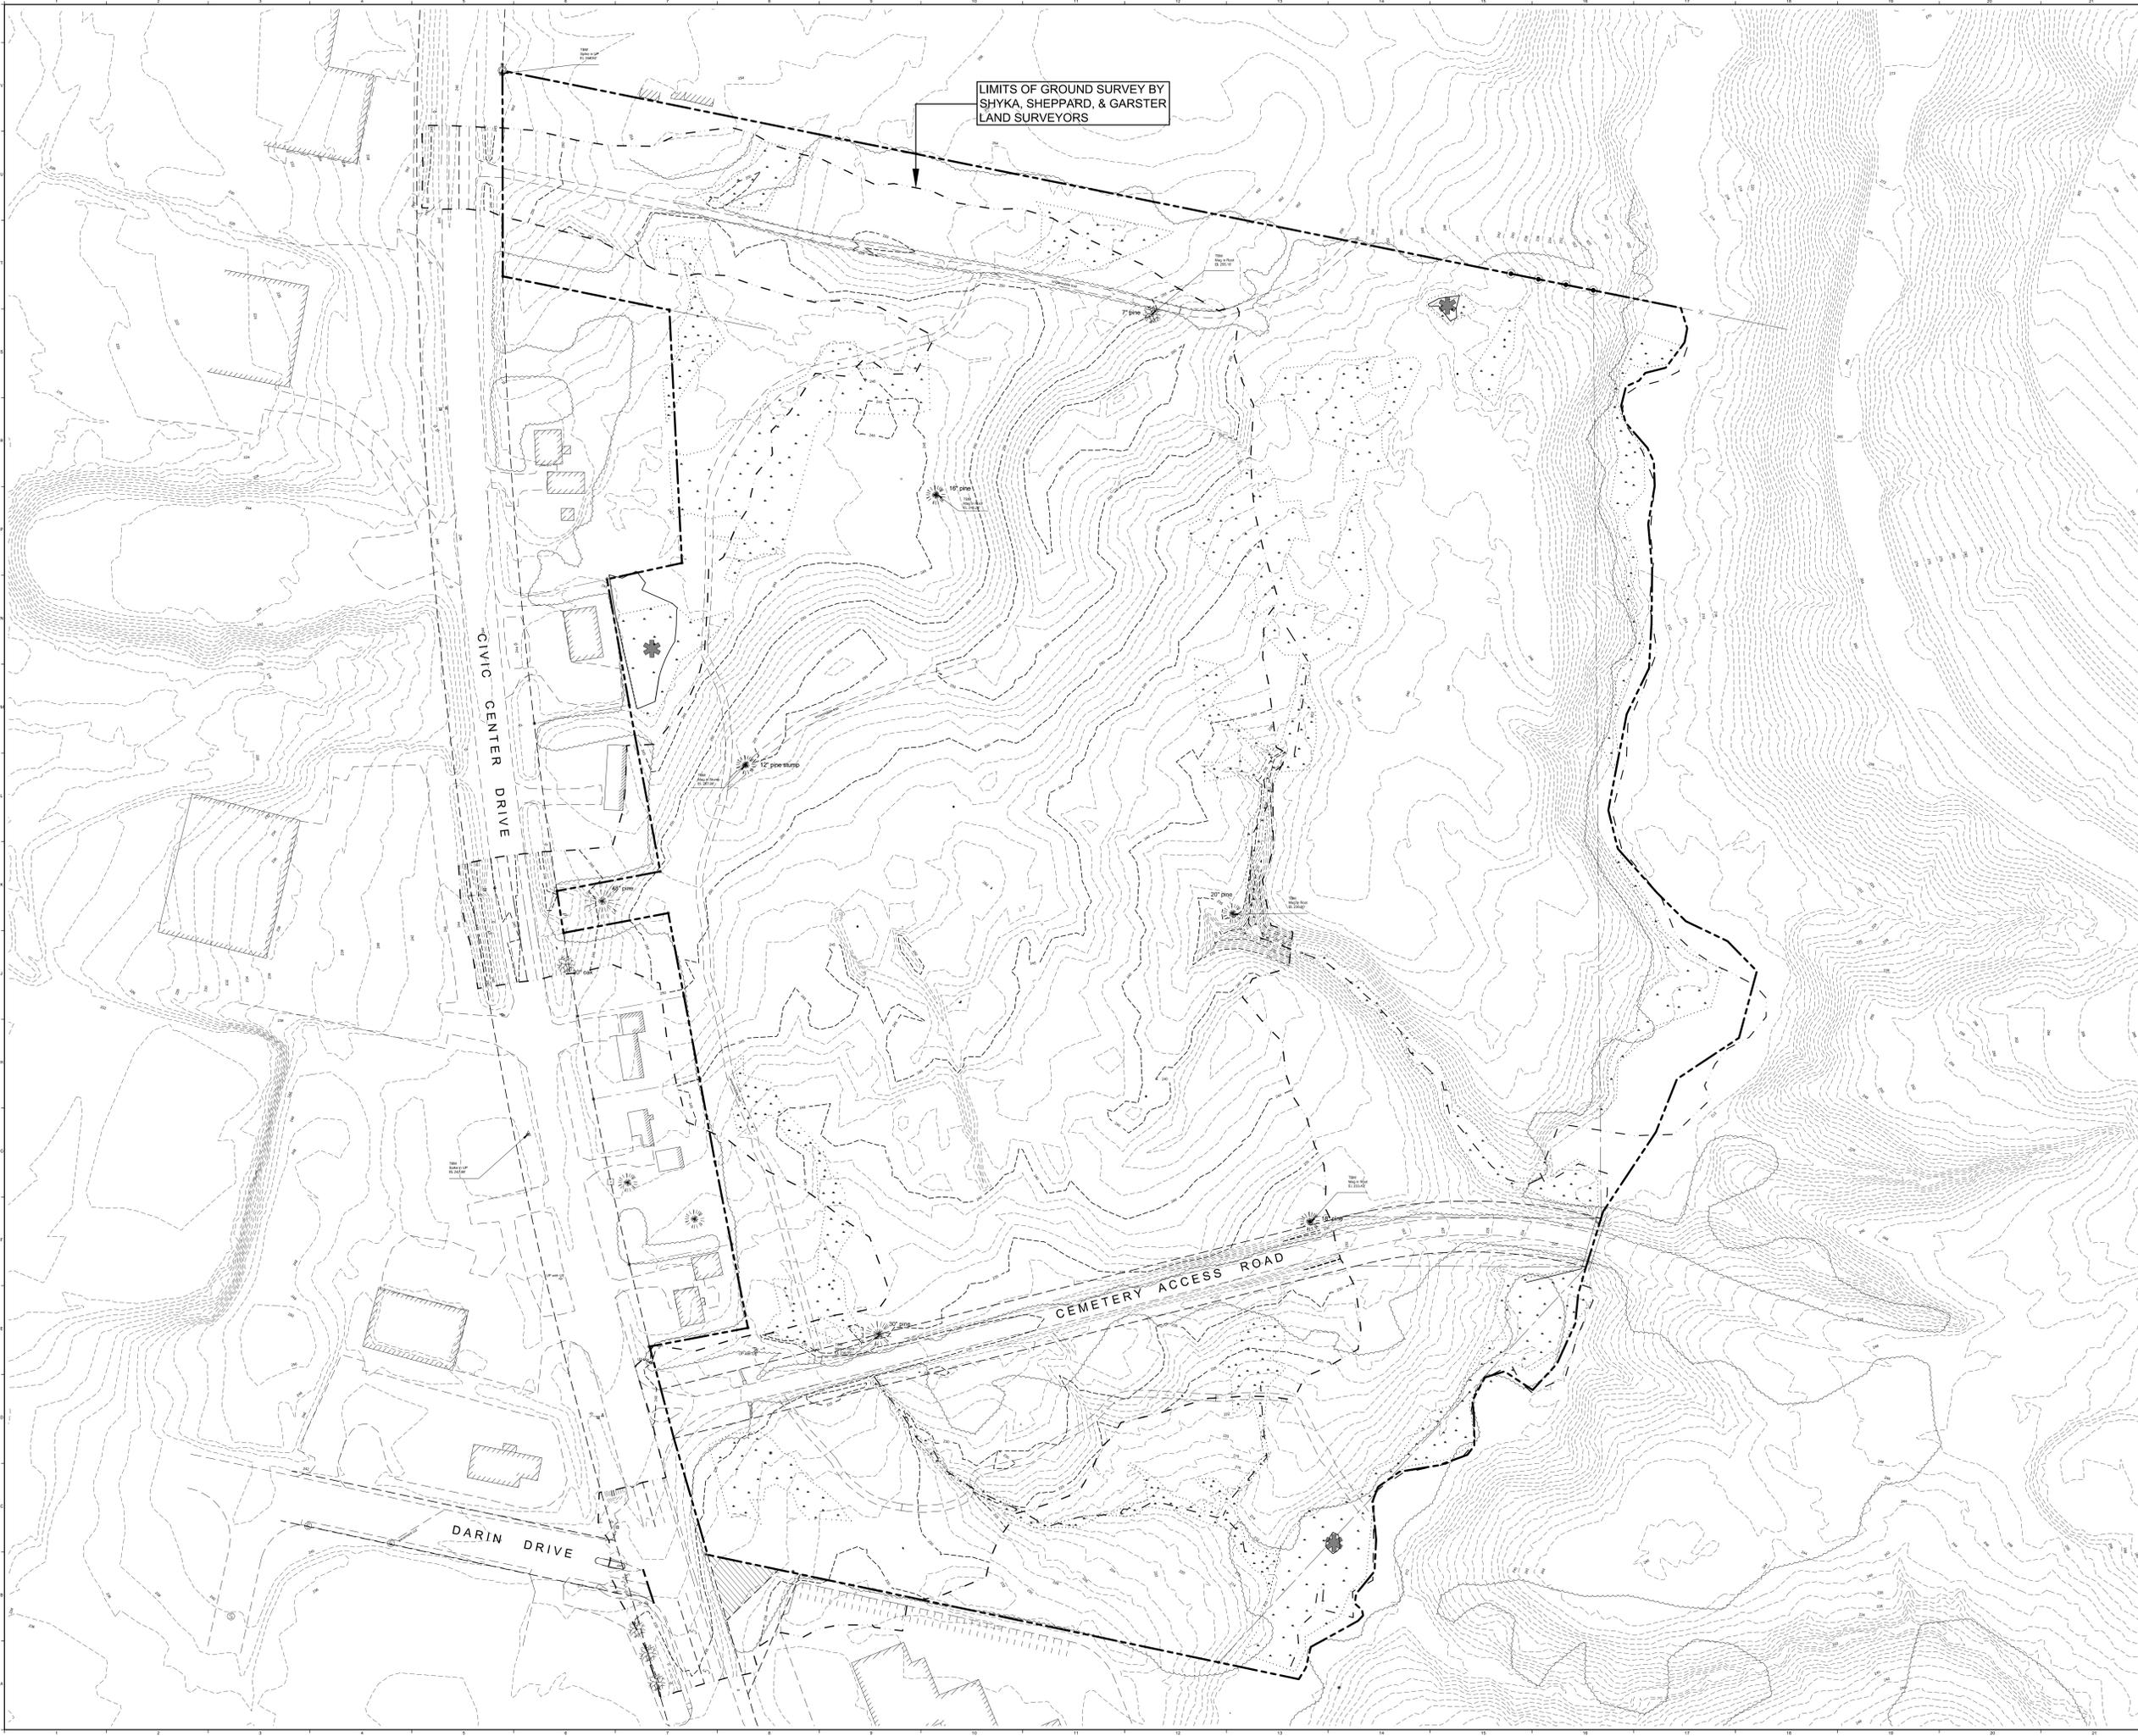

LIMITS OF GROUND SURVEY BY
SHYKA, SHEPPARD, & GARSTER
LAND SURVEYORS


- PLAN REFERENCE:**
1. THE BOUNDARY INFORMATION SHOWN ON THIS PLAN IS BASED ON A SITE SURVEY PROVIDED BY MORRIS LAND SURVEYORS, PROJECT # A1152K, DATED 01-18-2012.
 2. WETLANDS, PIP & STREAM CENTERLINE GIS INFORMATION PROVIDED BY CES INC. RECEIVED 03-14-2012.
 3. SITE FEATURES, GRADING & ELEVATION INFORMATION WITHIN THE BOUNDARY SHOWN IS BASED ON A SURVEY BY SHYKA, SHEPPARD & GARSTER LAND SURVEYORS, DATED: 01-18-2013.
 4. ALL ADDITIONAL SITE FEATURES, GRADING & ELEVATION INFORMATION IS BASED ON MAINE STATE GIS & SITE OBSERVATIONS BY WBRC A/E.

THIS INFORMATION IS NOT PART OF THE
CONTRACT DOCUMENTS AND IS FOR
INFORMATIONAL PURPOSES ONLY

REV.	DESCRIPTION	DATE

APPROVAL DRAWINGS
05.07.14

 CURRENT ISSUE STATUS:



WBRC
ARCHITECTS + ENGINEERS

O'BrienAtkins
ARCHITECTS + ENGINEERS

O'BrienAtkins Associates, PA 910.941.3000 - Durham
PO Box 1025 910.941.3000 - Raleigh
Research Triangle Park 910.941.3000 - Fax
High Campus Drive www.obrienatkins.com

JOINT FORCE
HEADQUARTERS -
PHASE I PN, 230113

PROJECT: AUGUSTA, MAINE

SITE EXISTING
CONDITIONS MAP

SHEET TITLE:	375200 CS101.DWG
PROJECT NO.:	3752.00
SCALE:	1"=50'
PROJECT MANAGER:	MLW
DRAWN BY:	TAR
CHECKED BY:	ARB/PAM
SHEET NO.:	CS101


May 07, 2014 11:20am
 C:\B1\3001\375200\Joint Force Headquarters - Phase I\Design\Drawings\CS101.dwg - oledisplay



PLAN REFERENCE:
 1. THE BOUNDARY INFORMATION SHOWN ON THIS PLAN IS BASED ON A SITE SURVEY PROVIDED BY MORRISLAND SURVEYORS, PROJECT # A102K, DATED 01-18-2012.
 2. WETLANDS, PVP & STREAM CENTERLINE GIS INFORMATION PROVIDED BY CES INC. RECEIVED 03-14-2012.
 3. THE EXISTING CONDITIONS INFORMATION SHOWN ON THIS PLAN ARE APPROXIMATE AND ARE BASED ON A SURVEY COMPLETED BY SHYKA, SHEPPARD, & GARSTER LAND SURVEYORS. THE SITE CONTRACTOR SHALL FIELD VERIFY ALL EXISTING SITE CONDITIONS PRIOR TO BEGINNING ANY SITE CLEARING, UTILITY OR EARTHWORK ACTIVITIES.

EXISTING	LEGEND	PROPOSED
UTILITY POLE	UTILITY POLE	GUY WIRE
WATER SHUTOFF / GATE VALVE	SEWER MANHOLE	CATCH BASIN
FIRE HYDRANT	SIGN	FENCING
PAVEMENT REMOVALS	LIMITS OF CONSTRUCTION	PROPERTY SETBACK
PROPERTY LINE	ADJUTING PROPERTY LINE	TREE REMOVALS
WETLAND IMPACT		

REV. DESCRIPTION DATE
 APPROVAL DRAWINGS
 05.07.14

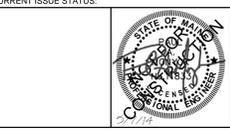

WBRC
 ARCHITECTS + ENGINEERS
 WWW.WBRCAE.COM
 BANGOR, MAINE 04401-4111
 PORTLAND, MAINE 307-828-4111
 SAN ANTONIO, TEXAS 361-554-0071

O'BrienAtkins
 Architects + Engineers
 919.941.9200 - Durham
 919.286.1212 - Raleigh
 919.941.9200 - Fax
 www.obrienatkins.com

JOINT FORCE
 HEADQUARTERS -
 PHASE I PN, 230113
 AUGUSTA, MAINE

**SITE OVERALL
 REMOVALS PLAN**
 SHEET TITLE: 375200 SP101.DWG
 PROJECT No: 3752.00 SHEET No: 07
 SCALE: 1"=50'
 PROJECT MANAGER: MLW
 DRAWN BY: TAR
 CHECKED BY: ARB
CD100

SEE SHEETS CD101, CD102, AND CD103
 FOR MORE DETAILED INFORMATION
 RELATED TO SITE REMOVALS



W:\05_2014\05_2014_375200_Site_Excise_Headquarters\Design\Drawings\375200_SP101.dwg_05.07.14
 4:30 PM 5/7/2014 1:37:20 PM

